

DATE: 03/04/2016

ADDENDUM NO. 1  
TO  
CONSTRUCTION DOCUMENTS

PROJECT NO.: E030300 Rebid  
DESCRIPTION: New Boat Dock at Fairfield Marina  
LOCATION: Brookville Reservoir, Franklin County IN  
FOR AGENCY: Department of Natural Resources

The information contained in this Addendum shall become a part of the basic plans and specifications the same as if originally incorporated therein. The original plans and specifications shall remain in their entirety, except as explained by this Addendum. The items herein shall supersede information in the specifications and on the plans.

ITEM NO. 1:




The following Plans are released to the Request for Bids Package:

E-1-- ELECTRIC PLANS BOAT DOCK  
P-1-- PLUMBING PLANS BOAT DOCK  
P-2-- PLUMBING DETAILS

END OF ADDENDUM


State Form 21208R4

DAPW-118

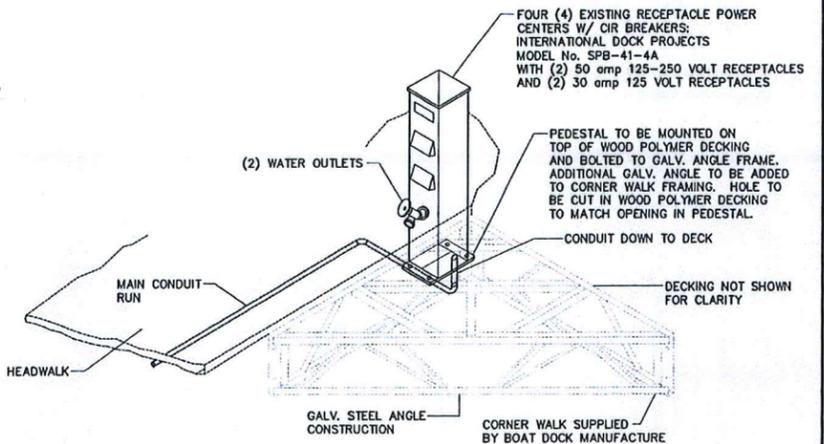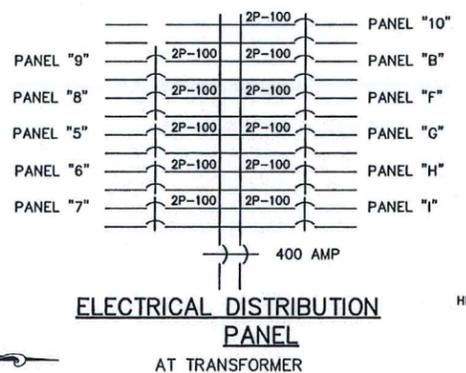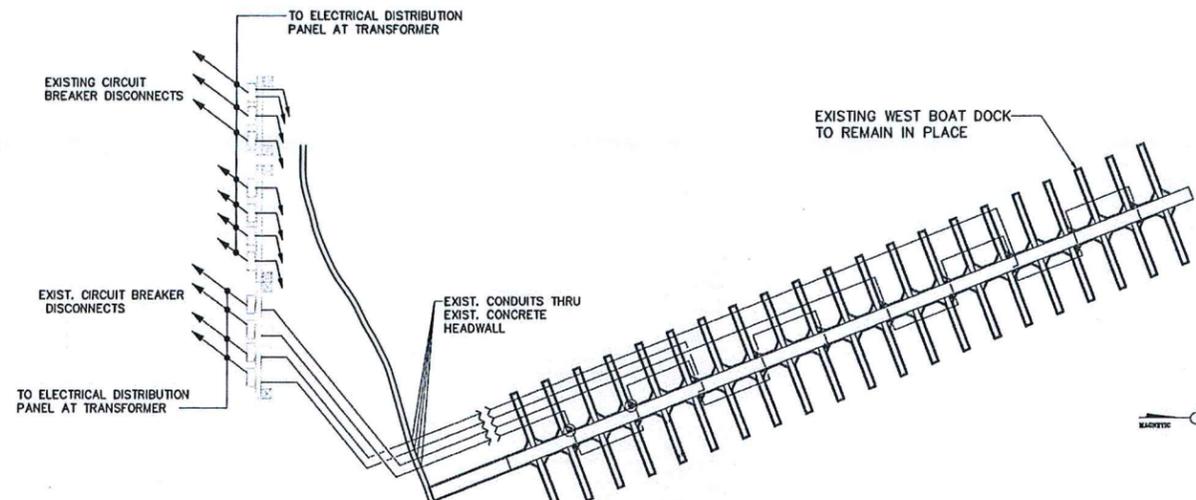

**EXISTING HOUSE BOAT DOCK OUTLET DETAIL** 1 SH 5


NO SCALE

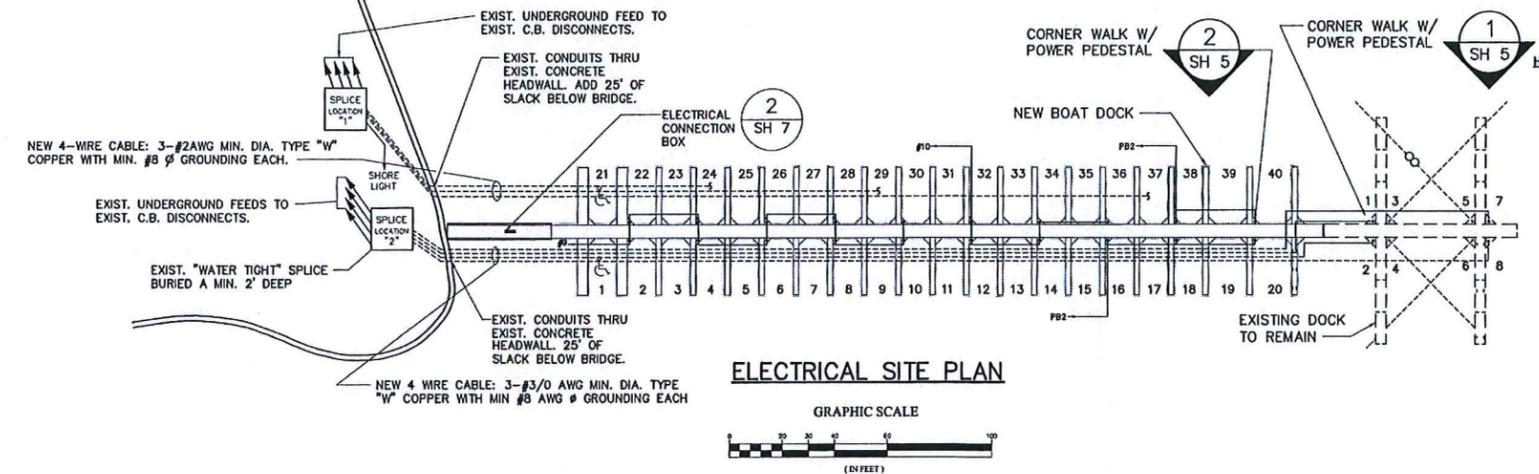

- HYPower**
- HYPower "ENERGY MATE" POWER PEDESTAL WITH:**
1. NON-CONDUCTIVE POLYCARBONATE INJECTION MOLDED BODY WITH UV PROTECTION.
  2. PREWIRED WITH STANDARD COPPER WIRE TO 200 AMPERE WITH PROVIDED NON-METALLIC SEPARATION OF HIGH-VOLTAGE AND LOW-VOLTAGE.
  3. FIELD WIRING TERMINALS TO 2 AWG WIRE.
  4. LOCKABLE HINGED DOOR WITH PADLOCK.
  5. PHOTO-CELL ACTIVATED LIGHTING WITH A 5W LED BULB AND WITH A CLEAR LENS.
  6. (2) RECEPTACLES AND BREAKERS TO BE 20A TWISTLOCK MARINE/RV WITH MATCHING GFCI BREAKERS.
  7. UL CERTIFIED, ADA COMPLIANT, AND MEETS OR EXCEEDS ALL NEC AND NFPA REQUIREMENTS.


1 1/2" RIGID CONDUIT W/ 3-#12 WIRES PLUS GROUND UP TO POWER CENTER

MIDWEST ELECTRICAL PRODUCTS INC. TERMINAL BOX NEMA 3R MODEL No. T 1210 W/GROUND BAR

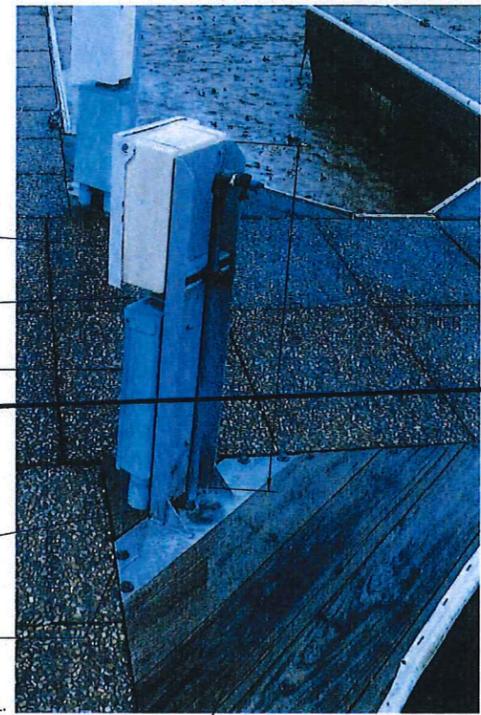

**NEW BOAT DOCK OUTLET DETAIL** 2 SH 5

NO SCALE

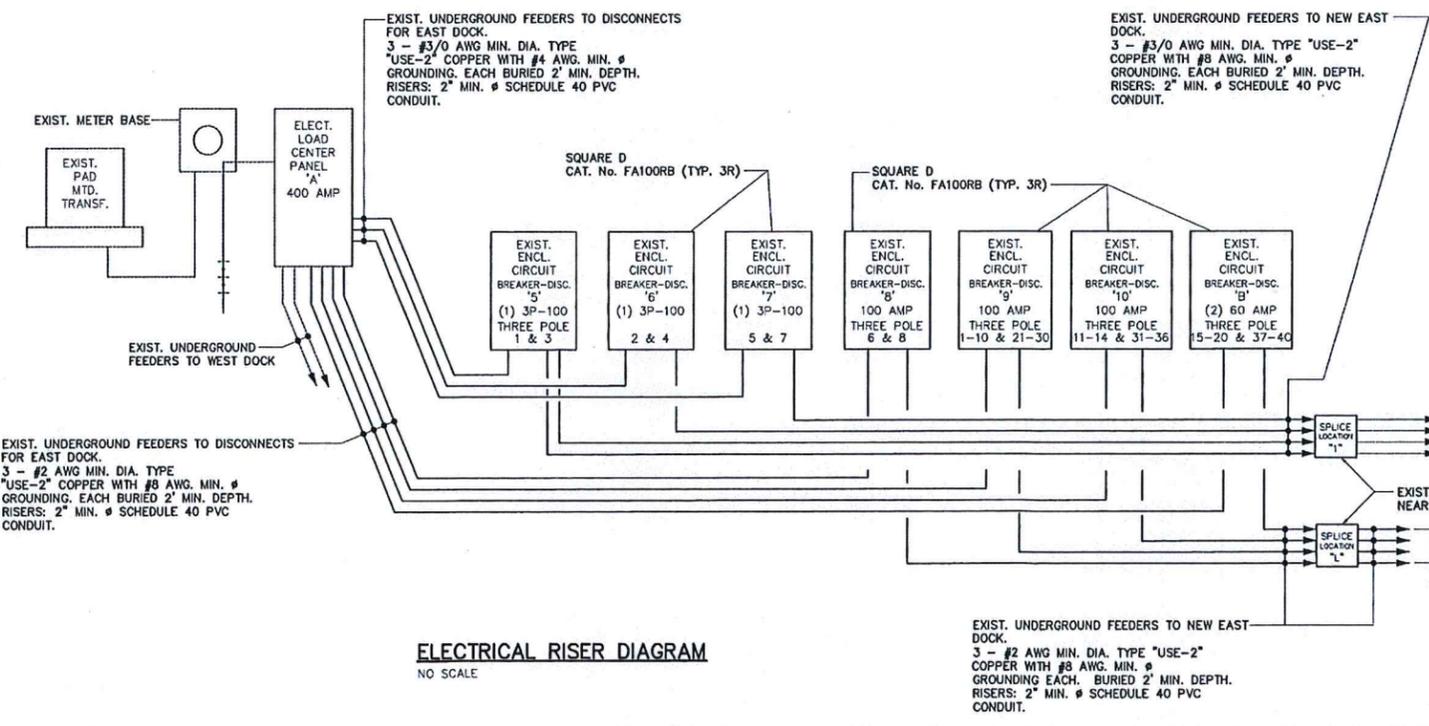

**NOTE:**

**ALUMINUM PEDESTAL**

FABRICATE PEDESTAL FROM 8"x3"x0.350" ALUMINUM CHANNEL. ALUMINUM POST TO BE 3'-0" HIGH FROM TOP OF ALUM. BASE. WELD POST TO BASE AND ADD 2"x2"x45" BRACE AS SHOWN IN PICTURE. BASE TO BE MADE FROM 5"x2"x0.187" ALUM. CHANNEL. BASE TOP TO BE FLUSH WITH WOOD-POLYMER DECK AND BOLTED TO 2'x2' CORNER WALK FRAME WITH (4) 1/2" ALUM. BOLTS, NUTS, AND WASHERS, SHOWN IN PICTURE.

(10) PEDESTAL'S TO HAVE PLAIN BACK.

(10) PEDESTAL'S TO HAVE BRACKET TO HOLD GALVANIZED WATER PIPE AS SHOWN IN PICTURE. SEE DETAIL 1 SHEET 7.

- SYMBOLS**
- RECEPTACLE POST, TWO (4) OUTLETS EA.
  - CONNECTION POINT OF CONDUIT.
  - NEW PANEL BOARD & PANEL / DISCONNECTS.
  - NEW CONDUIT UNDER DOCK TO PANEL BOARD.

"HOLEY MOLEY" SAYS CALL AT LEAST TWO FULL WORKING DAYS BEFORE YOU DIG. IT'S THE LAW

1-800-382-5544 CALL TOLL FREE



SITEPLAN & DETAILS

BROOKVILLE LAKE FAIRFIELD MARINA  
FLOATING BOAT DOCK  
DEPT. OF NATURAL RESOURCES  
14108 ST. RD. 101  
BROOKVILLE, IN. 47012-9791



Project Number:	Project# E030300
Requisition Number:	Requisition#
Designer:	Drawing Date: 1/20/16
Drafter:	Drawing Scale: AS NOTED
DNR Approval:	
Client Approval:	
File Number:	305-57
Drawing Number:	E-1
Sheet:	5 of 7



Certified by:  
*Ronald G. Peterson*

PLUMBING SITE PLAN  
 &  
 DETAILS



P-1  
 FLOATING BOAT DOCK  
 DEPT. OF NATURAL RESOURCES  
 14108 ST. RD. 101  
 BROOKVILLE, IN. 47012-9791




STATE OF INDIANA  
 DEPARTMENT OF NATURAL RESOURCES  
 DIVISION OF ENGINEERING  
 ROOM W39, INDIANA GOVERNMENT CENTER SOUTH  
 402 WEST WASHINGTON STREET  
 INDIANAPOLIS, INDIANA 46204  
 TEL. 317-232-4150, FAX 317-232-1285

Jan 20, 2016 - 2:55pm B:\ACTIVE\PROJECTS\ENGINEERING\BROOKVILLE\CONTRACTS\Line Item 204 - Floating Boat Dock\DWG\Boat Dock Plumbing.dwg


Revisions:	
Project Number:	Project# E030300
Requisition Number:	Requisition#
Designer:	Drawing Date: 1/20/16
Drafter:	Drawing Scale: AS NOTED
DNR Approval:	
Client Approval:	
File Number:	305-57
Drawing Number:	P-1
Sheet:	6 of 7

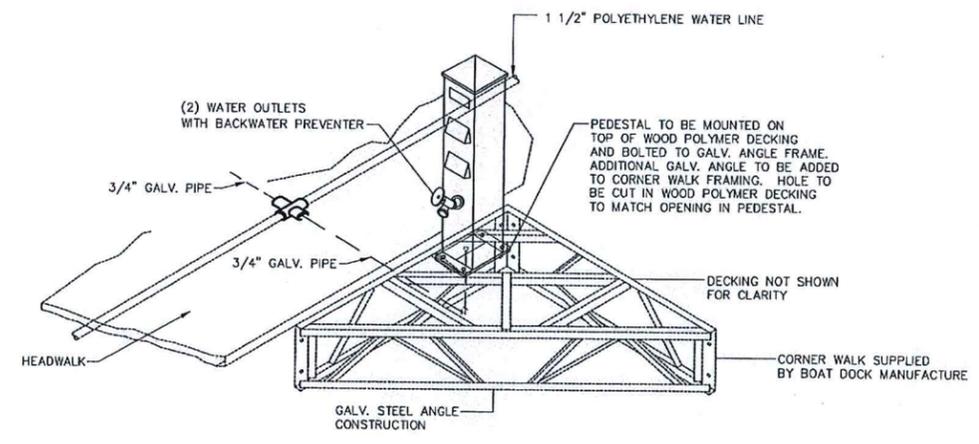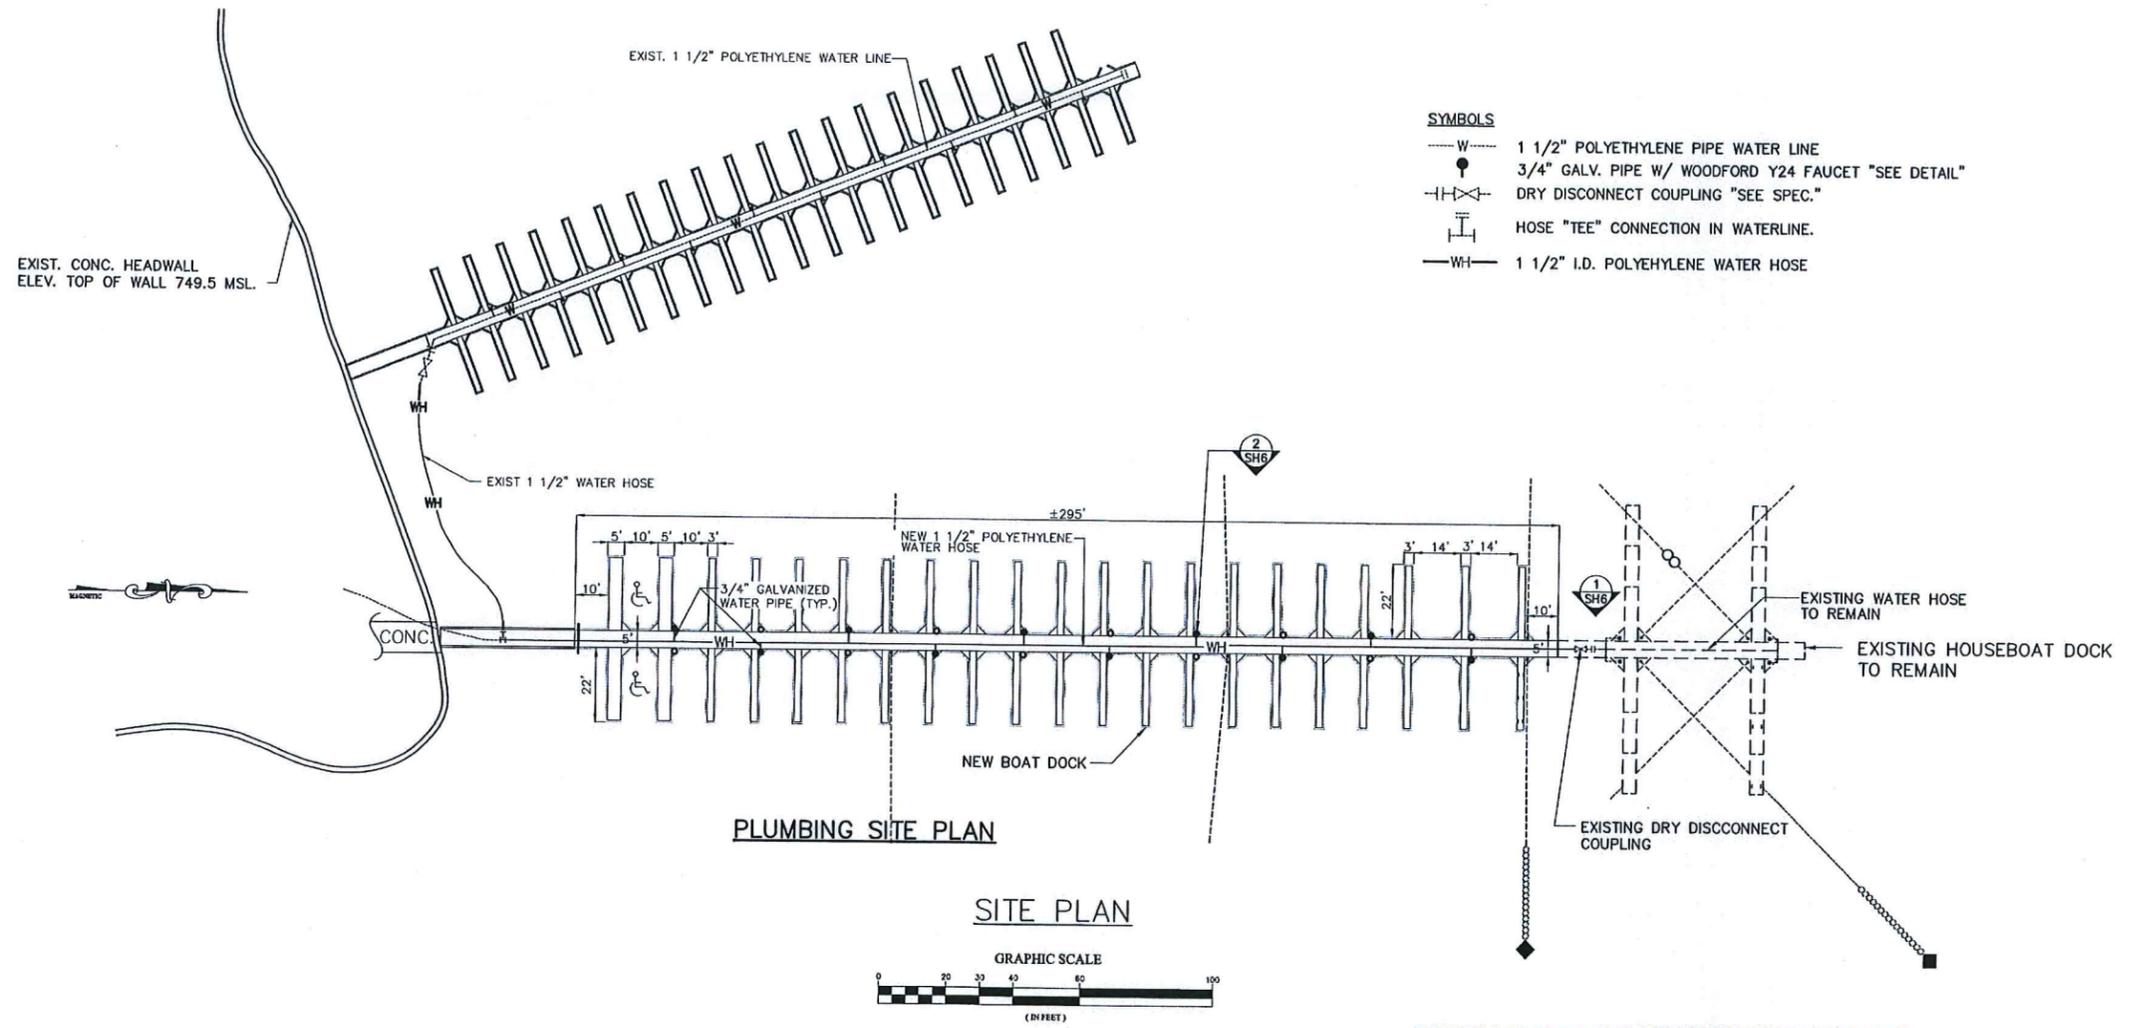


**EXISTING WATER FAUCET MOUNTING DETAIL**  
 NO SCALE  
 1 SH6

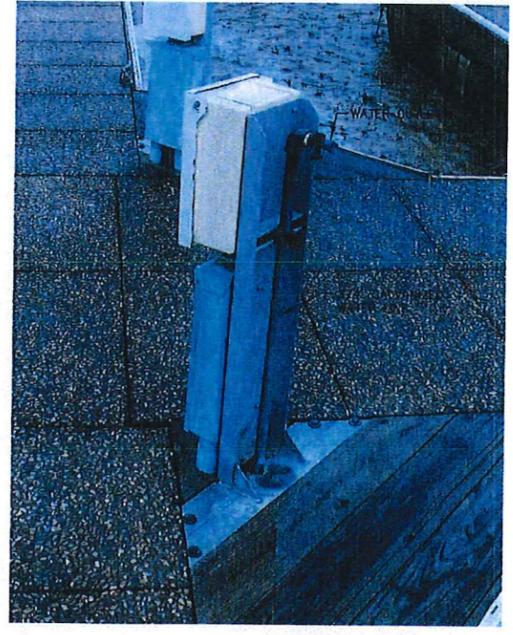


**NEW WATER FAUCET MOUNTING DETAIL**  
 NO SCALE  
 2 SH6

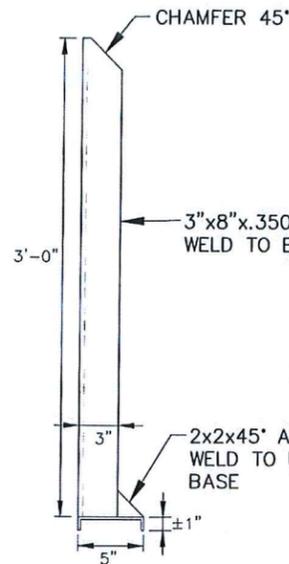

SIDE VIEW

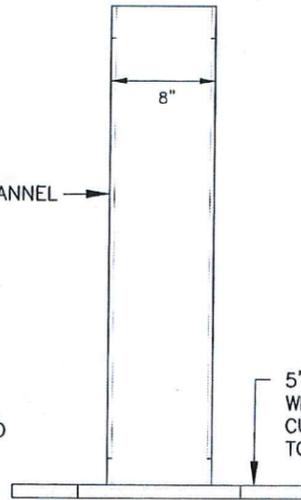


FRONT VIEW

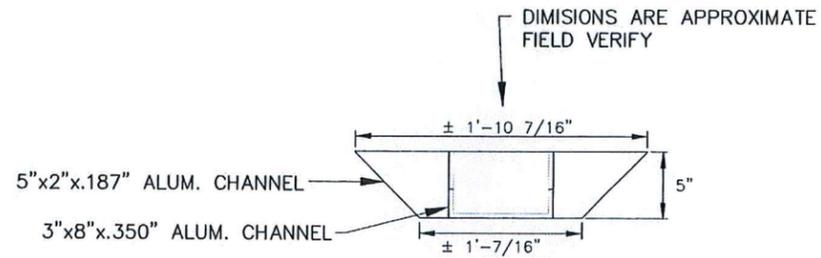


TOP VIEW

**ALUMINUM PEDESTAL DETAIL** (1/SH 7)  
NO SCALE

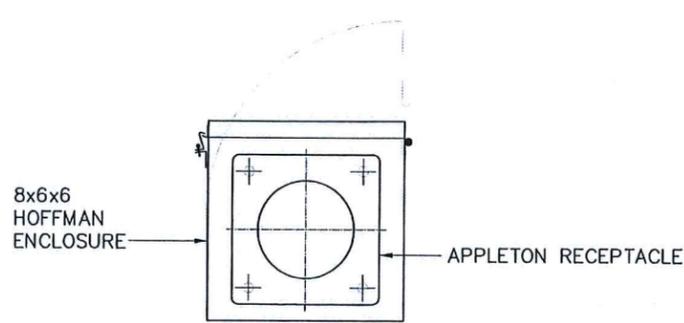

END VIEW

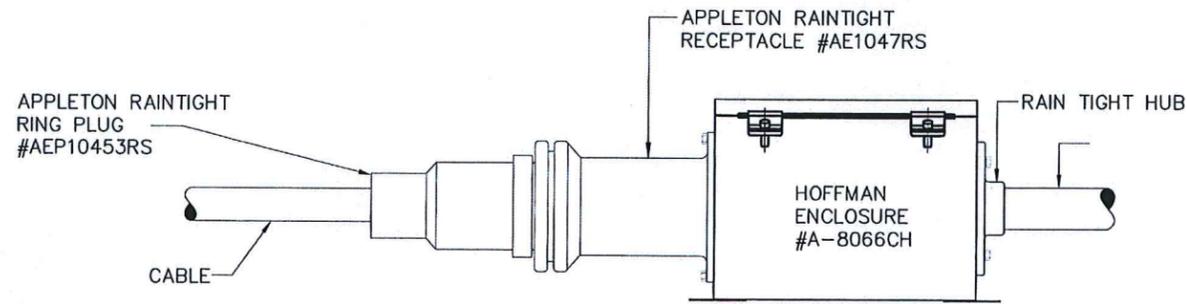

SIDE VIEW

**ELECTRICAL CONNECTION** (2/SH 7)  
NO SCALE



DETAILS

BROOKVILLE LAKE FAIRFIELD MARINA  
FLOATING BOAT DOCK  
DEPT. OF NATURAL RESOURCES  
14108 ST. RD. 101  
BROOKVILLE, IN. 47012-9791



Project Number: Project# E030300	
Requisition Number: Requisition#	
Designer: 1/20/16	Drawing Date:
Driller: AS NOTED	Drawing Scale:
DNR Approval:	
Client Approval:	
File Number: 305-57	
Drawing Number: P-2	
Sheet: 7 of 7	